


Checked and found ok for Public Health
(General) Sanitation subject to comments in
in drawing No. SEI/1644/16-17
Specialist
HUDA, Panchsara
(BALWANT SINGH) S.D.
1:100
Scale
Drawing No.
06
FIRST FLOOR PLAN

1. 100mm WASTE & VENT PIPE FOR KITCHEN
2. 100mm WASTE & VENT PIPE FOR SHOP
3. 75mm VENT PIPE
4. 100mm WASTE & VENT PIPE FOR KITCHEN
5. 100mm WASTE & VENT PIPE FOR SHOP
6. 100mm WASTE & VENT PIPE FOR KITCHEN
7. 100mm WASTE & VENT PIPE FOR SHOP
8. 100mm WASTE & VENT PIPE FOR KITCHEN
9. 100mm WASTE & VENT PIPE FOR SHOP
10. 100mm WASTE & VENT PIPE FOR KITCHEN
11. 100mm WASTE & VENT PIPE FOR SHOP
12. 100mm WASTE & VENT PIPE FOR KITCHEN
13. 100mm WASTE & VENT PIPE FOR SHOP
14. 100mm WASTE & VENT PIPE FOR KITCHEN
15. 100mm WASTE & VENT PIPE FOR SHOP
16. 100mm WASTE & VENT PIPE FOR KITCHEN
17. 100mm WASTE & VENT PIPE FOR SHOP
18. 100mm WASTE & VENT PIPE FOR KITCHEN
19. 100mm WASTE & VENT PIPE FOR SHOP
20. 100mm WASTE & VENT PIPE FOR KITCHEN
21. 100mm WASTE & VENT PIPE FOR SHOP
22. 100mm WASTE & VENT PIPE FOR KITCHEN
23. 100mm WASTE & VENT PIPE FOR SHOP
24. 100mm WASTE & VENT PIPE FOR KITCHEN
25. 100mm WASTE & VENT PIPE FOR SHOP
26. 100mm WASTE & VENT PIPE FOR KITCHEN
27. 100mm WASTE & VENT PIPE FOR SHOP
28. 100mm WASTE & VENT PIPE FOR KITCHEN
29. 100mm WASTE & VENT PIPE FOR SHOP
30. 100mm WASTE & VENT PIPE FOR KITCHEN
31. 100mm WASTE & VENT PIPE FOR SHOP
32. 100mm WASTE & VENT PIPE FOR KITCHEN
33. 100mm WASTE & VENT PIPE FOR SHOP
34. 100mm WASTE & VENT PIPE FOR KITCHEN
35. 100mm WASTE & VENT PIPE FOR SHOP
36. 100mm WASTE & VENT PIPE FOR KITCHEN
37. 100mm WASTE & VENT PIPE FOR SHOP
38. 100mm WASTE & VENT PIPE FOR KITCHEN
39. 100mm WASTE & VENT PIPE FOR SHOP
40. 100mm WASTE & VENT PIPE FOR KITCHEN
41. 100mm WASTE & VENT PIPE FOR SHOP
42. 100mm WASTE & VENT PIPE FOR KITCHEN
43. 100mm WASTE & VENT PIPE FOR SHOP
44. 100mm WASTE & VENT PIPE FOR KITCHEN
45. 100mm WASTE & VENT PIPE FOR SHOP
46. 100mm WASTE & VENT PIPE FOR KITCHEN
47. 100mm WASTE & VENT PIPE FOR SHOP
48. 100mm WASTE & VENT PIPE FOR KITCHEN
49. 100mm WASTE & VENT PIPE FOR SHOP
50. 100mm WASTE & VENT PIPE FOR KITCHEN
51. 100mm WASTE & VENT PIPE FOR SHOP
52. 100mm WASTE & VENT PIPE FOR KITCHEN
53. 100mm WASTE & VENT PIPE FOR SHOP
54. 100mm WASTE & VENT PIPE FOR KITCHEN
55. 100mm WASTE & VENT PIPE FOR SHOP
56. 100mm WASTE & VENT PIPE FOR KITCHEN
57. 100mm WASTE & VENT PIPE FOR SHOP
58. 100mm WASTE & VENT PIPE FOR KITCHEN
59. 100mm WASTE & VENT PIPE FOR SHOP
60. 100mm WASTE & VENT PIPE FOR KITCHEN
61. 100mm WASTE & VENT PIPE FOR SHOP
62. 100mm WASTE & VENT PIPE FOR KITCHEN
63. 100mm WASTE & VENT PIPE FOR SHOP
64. 100mm WASTE & VENT PIPE FOR KITCHEN
65. 100mm WASTE & VENT PIPE FOR SHOP
66. 100mm WASTE & VENT PIPE FOR KITCHEN
67. 100mm WASTE & VENT PIPE FOR SHOP
68. 100mm WASTE & VENT PIPE FOR KITCHEN
69. 100mm WASTE & VENT PIPE FOR SHOP
70. 100mm WASTE & VENT PIPE FOR KITCHEN
71. 100mm WASTE & VENT PIPE FOR SHOP
72. 100mm WASTE & VENT PIPE FOR KITCHEN
73. 100mm WASTE & VENT PIPE FOR SHOP
74. 100mm WASTE & VENT PIPE FOR KITCHEN
75. 100mm WASTE & VENT PIPE FOR SHOP
76. 100mm WASTE & VENT PIPE FOR KITCHEN
77. 100mm WASTE & VENT PIPE FOR SHOP
78. 100mm WASTE & VENT PIPE FOR KITCHEN
79. 100mm WASTE & VENT PIPE FOR SHOP
80. 100mm WASTE & VENT PIPE FOR KITCHEN
81. 100mm WASTE & VENT PIPE FOR SHOP
82. 100mm WASTE & VENT PIPE FOR KITCHEN
83. 100mm WASTE & VENT PIPE FOR SHOP
84. 100mm WASTE & VENT PIPE FOR KITCHEN
85. 100mm WASTE & VENT PIPE FOR SHOP
86. 100mm WASTE & VENT PIPE FOR KITCHEN
87. 100mm WASTE & VENT PIPE FOR SHOP
88. 100mm WASTE & VENT PIPE FOR KITCHEN
89. 100mm WASTE & VENT PIPE FOR SHOP
90. 100mm WASTE & VENT PIPE FOR KITCHEN
91. 100mm WASTE & VENT PIPE FOR SHOP
92. 100mm WASTE & VENT PIPE FOR KITCHEN
93. 100mm WASTE & VENT PIPE FOR SHOP
94. 100mm WASTE & VENT PIPE FOR KITCHEN
95. 100mm WASTE & VENT PIPE FOR SHOP
96. 100mm WASTE & VENT PIPE FOR KITCHEN
97. 100mm WASTE & VENT PIPE FOR SHOP
98. 100mm WASTE & VENT PIPE FOR KITCHEN
99. 100mm WASTE & VENT PIPE FOR SHOP
100. 100mm WASTE & VENT PIPE FOR KITCHEN

RMK.	WIDTH	HEIGHT	CILL LVL LIN. LVL.
FD	1500	2600	---
FD1	1800	2600	---
FD2	2600	2600	---
GD	1200	2400	---
D	2400	2400	---
D1	1200	2400	---
D2	1000	2400	---
D3	750	2100	---

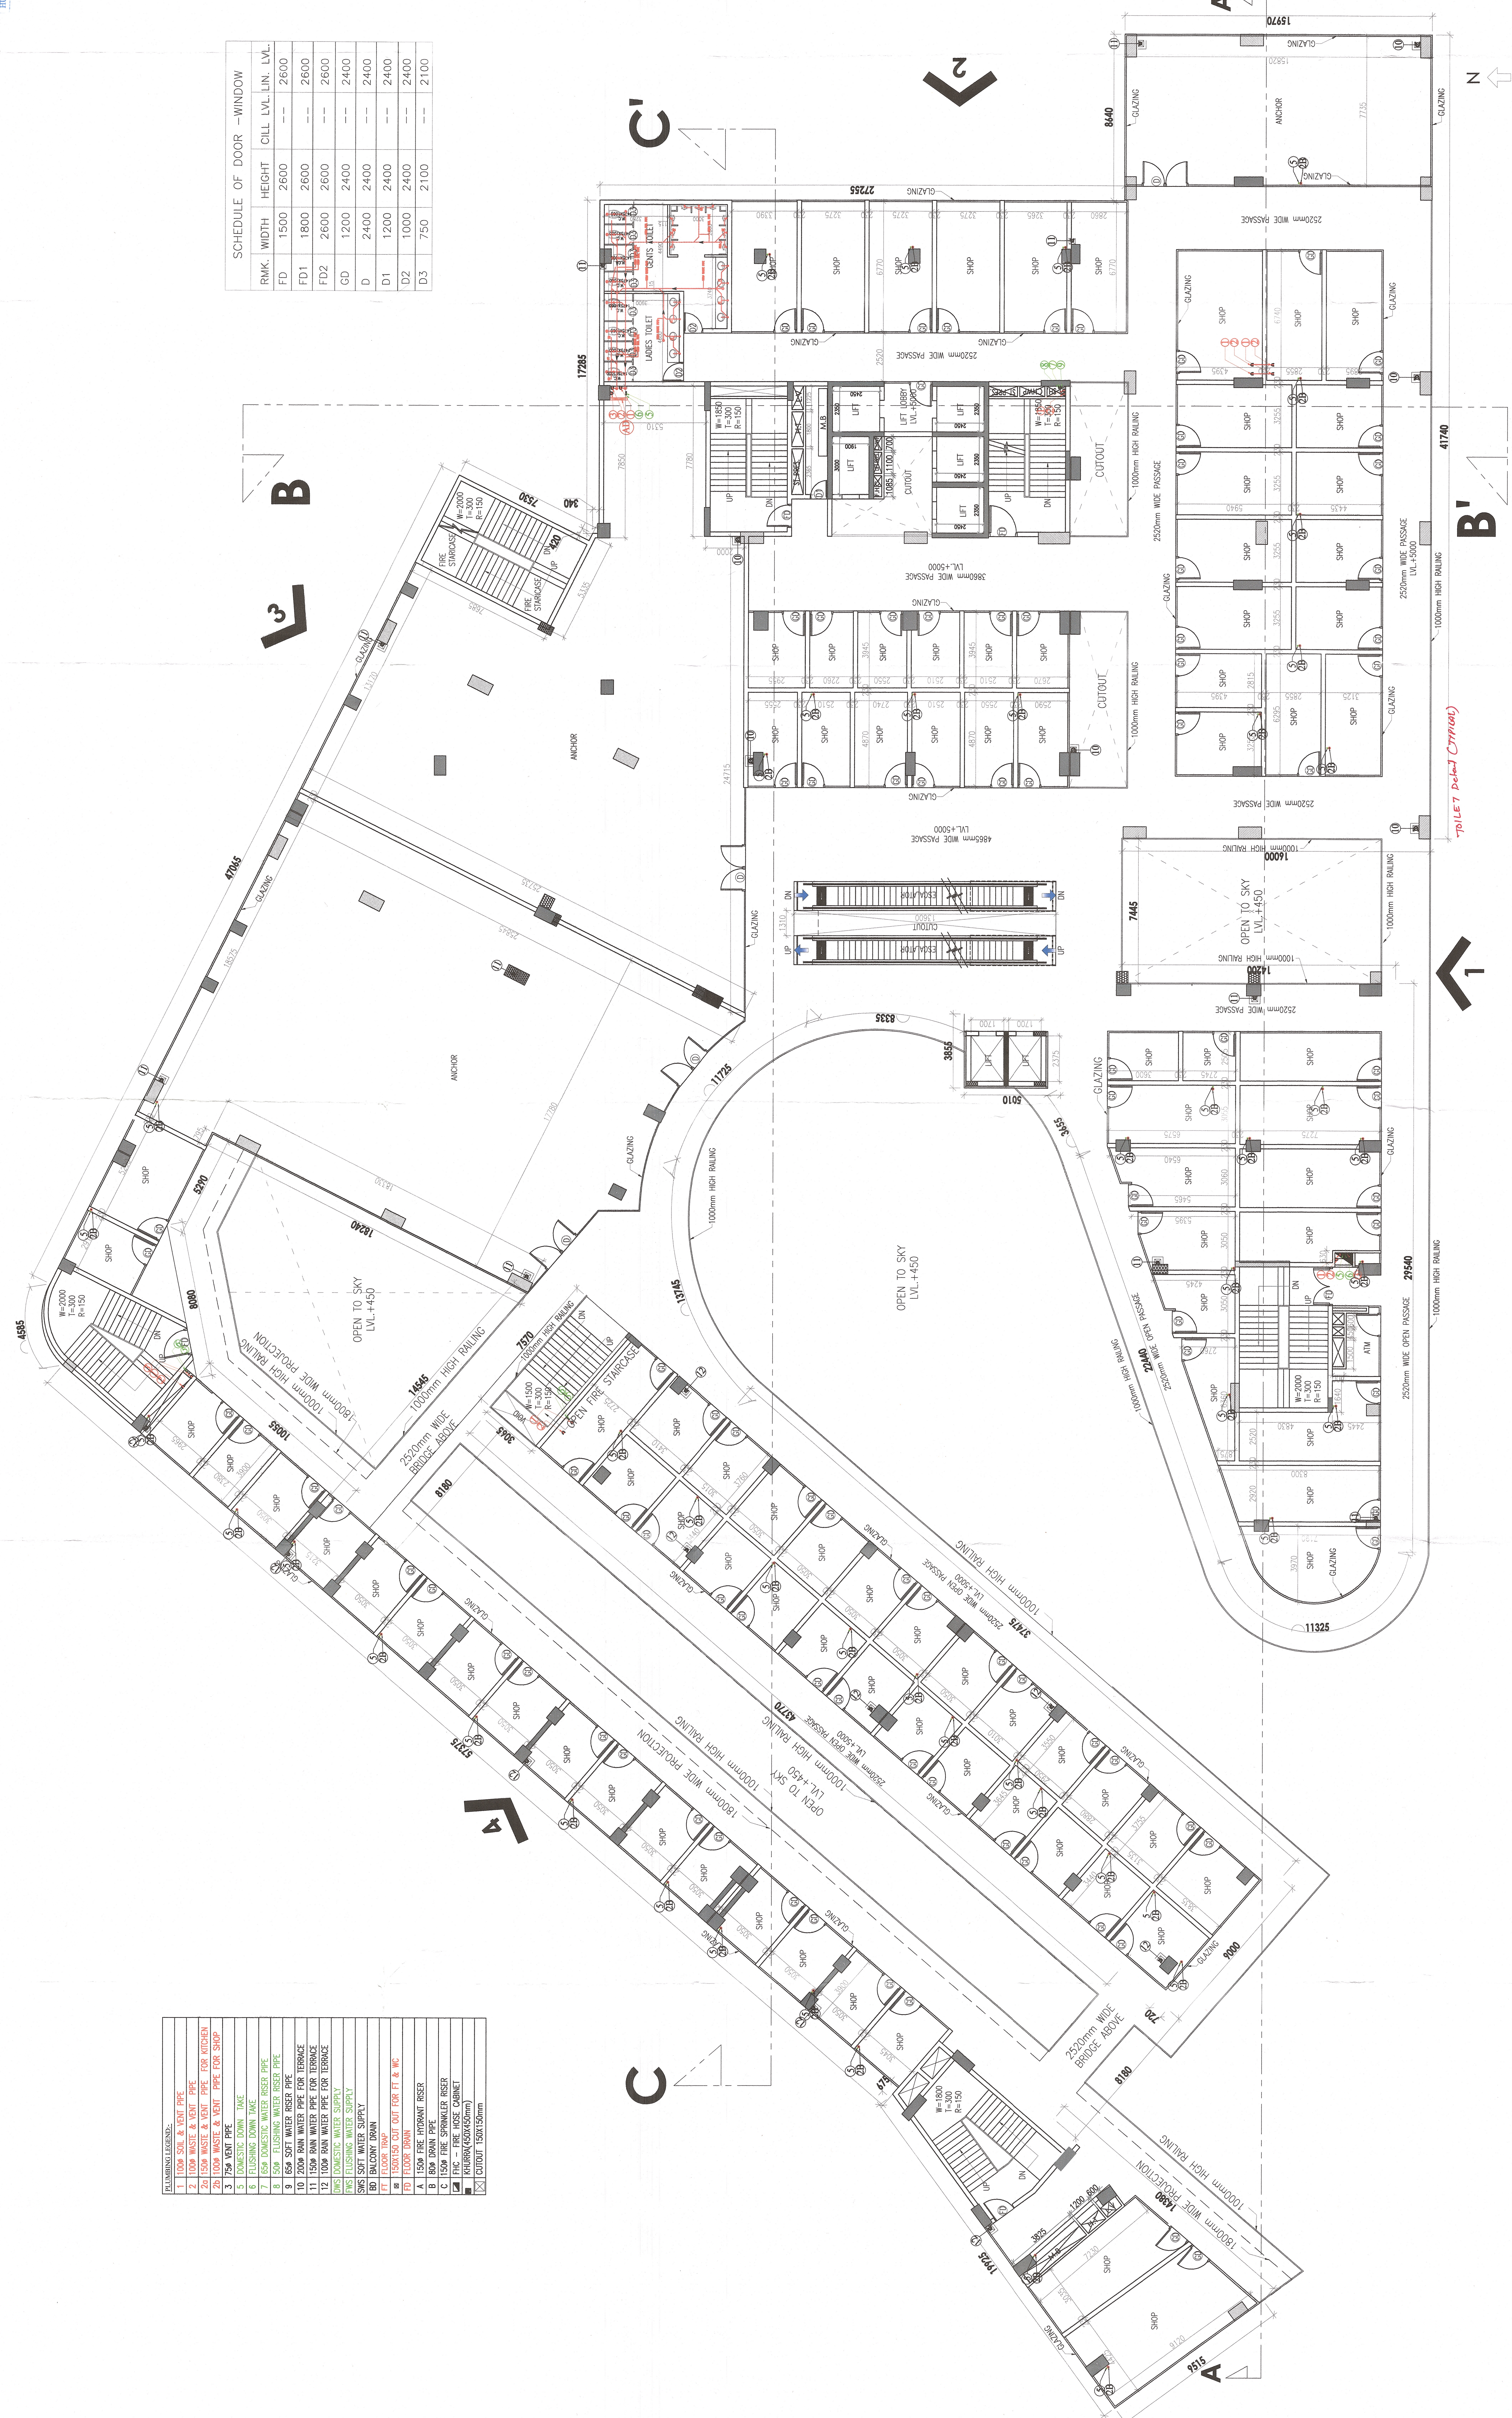

NOTE
1. YOU WILL HAVE TO PROVIDE THE C.F.L. AS PER THE DIRECTOR OF GOVT.
2. THE BUILDING SHALL BE EARTHQUAKE RESISTANT.
3. THE EARTHQUAKE RESISTANT SHALL BE THE STRUCTURE STABILITY OF BUILDING AGAINST THE EARTHQUAKE.
4. THE RAINWATER HARVESTING SYSTEM SHALL BE WATER AUTH. NORMS.
5. ALL BUILDING EXISTING SYSTEMS SHALL BE WATER AUTH. NORMS.
6. ALL BUILDING EXISTING SYSTEMS SHALL BE WATER AUTH. NORMS.
7. AND VENTILATED AS PER B.C.C. NORMS.
8. AND VENTILATED AS PER B.C.C. NORMS.
9. AND VENTILATED AS PER B.C.C. NORMS.
100. AND VENTILATED AS PER B.C.C. NORMS.

ARCHITECT
REVISED BUILDING PLAN OF
COMMERCIAL COUNTY MEASURING
2013 DATED 27.07.2013 IN SECTOR-92
GURGAON MANEER URBAN
SCALE TOWERS PVT. LTD.
SACHDEVA CONSULTANTS
Punjab, India
Gurgaon - 122002
Tel: 0124-4081801/4081802
email: sachdeva@rediffmail.com
www.sachdeva.com
Drawing No.
06
FIRST FLOOR PLAN